


ELECTRICAL LEGEND

●	CEILING LIGHT
○	WALL LIGHT
●	DOWN LIGHT
—	FLUORESCENT LIGHT - SINGLE
—	FLUORESCENT LIGHT - SINGLE WITH DIFFUSER
—	EXHAUST FAN - CEILING MOUNTED
—	EXHAUST FAN / LIGHT COMBINATION
—	EXHAUST FAN / LIGHT / HEATER COMBINATION
—	SMOKE DETECTOR
—	GPO 200 A.F.L. - SINGLE
—	GPO 200 A.F.L. - DOUBLE
—	GPO 875 A.F.L. OR AS NOMINATED - SINGLE
—	GPO 875 A.F.L. OR AS NOMINATED - DOUBLE
—	GPO 1018 A.F.L. - SINGLE
—	GPO 1018 A.F.L. - DOUBLE
—	GPO W/PROOF @ HEIGHT NOMINATED - SINGLE
—	GPO W/PROOF @ HEIGHT NOMINATED - DOUBLE
—	GAS NEGUS POINT & CEILING VENT
—	TELEPHONE POINT
—	T.V. POINT
—	TWO WAY SWITCHING

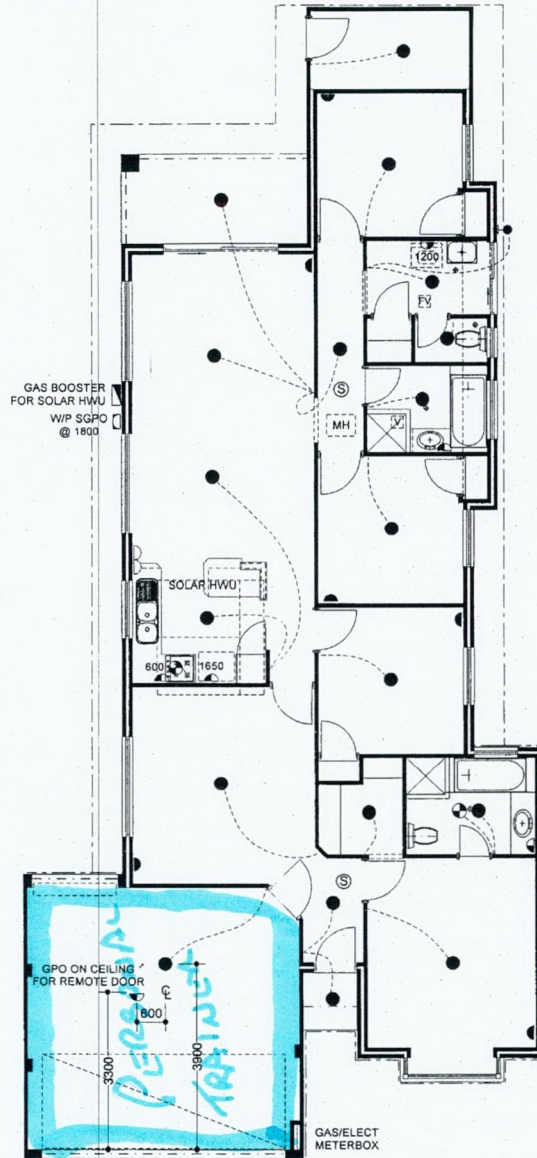

ELECTRICAL PLAN

1 : 100

COTTESLOE
2C FACEBRICK

© COPYRIGHT MODEL NO. 3503



23 FEB 2015
BY IMPRESSION
HQB/BUILDER

Reg. Subcontractor
65 Hasler Road, Osborne Park, W.A. 6007
Telephone: (08) 9231 4911, Facsimile: (08) 9231 4912
P.O. Box 115, Mt. Hawthorn, W.A. 6016
A Division of J. Corp Pty. Ltd.
ACN 099 080 076

REV	VO #	DRN	DATE	CHK
		JAD	10/02/05	GB

Sub-contractors to verify all dimensions on site.
Plans are subject to change pending structural engineer's requirements.
THIS IS ONE OF THE DRAWINGS REFERRED TO IN THE CONTRACT.

DATED: 10/02/05

OWNER: WITNESS
OWNER: WITNESS
BUILDER: WITNESS
CLIENT:

ADDRESS:
LOT 90 (HSE #18)
BROOKLYN AVENUE
PEARSALL

SHEET NO.	10 OF 11
DATE	5/9/02
REVISION	DATE

LOCATION	GRANO m²	BI/PAVED m²
V/dahs, Porches, Patios & Paths.	00.00	8.74
C/ports, Garages & Drives	33.24	22.57

DUG TO LEVEL 9.13
CENTRALLY ON LOT
(SAND FOUND)

Sandy
Light Grass Cover

NOTE:
LOT MISCLOSE
(0.002 m)

[illegible]

SHEET 11 OF 11

SITE SURVEY

LOT 90

Brooklyn Avenue


Suburb Pearsall

Loc.Auth. WANNEROC

D. Plan 36998 Volume 2542 Folio 632

Location	Check Title
----------	-------------

MAP REF.
252/21/07

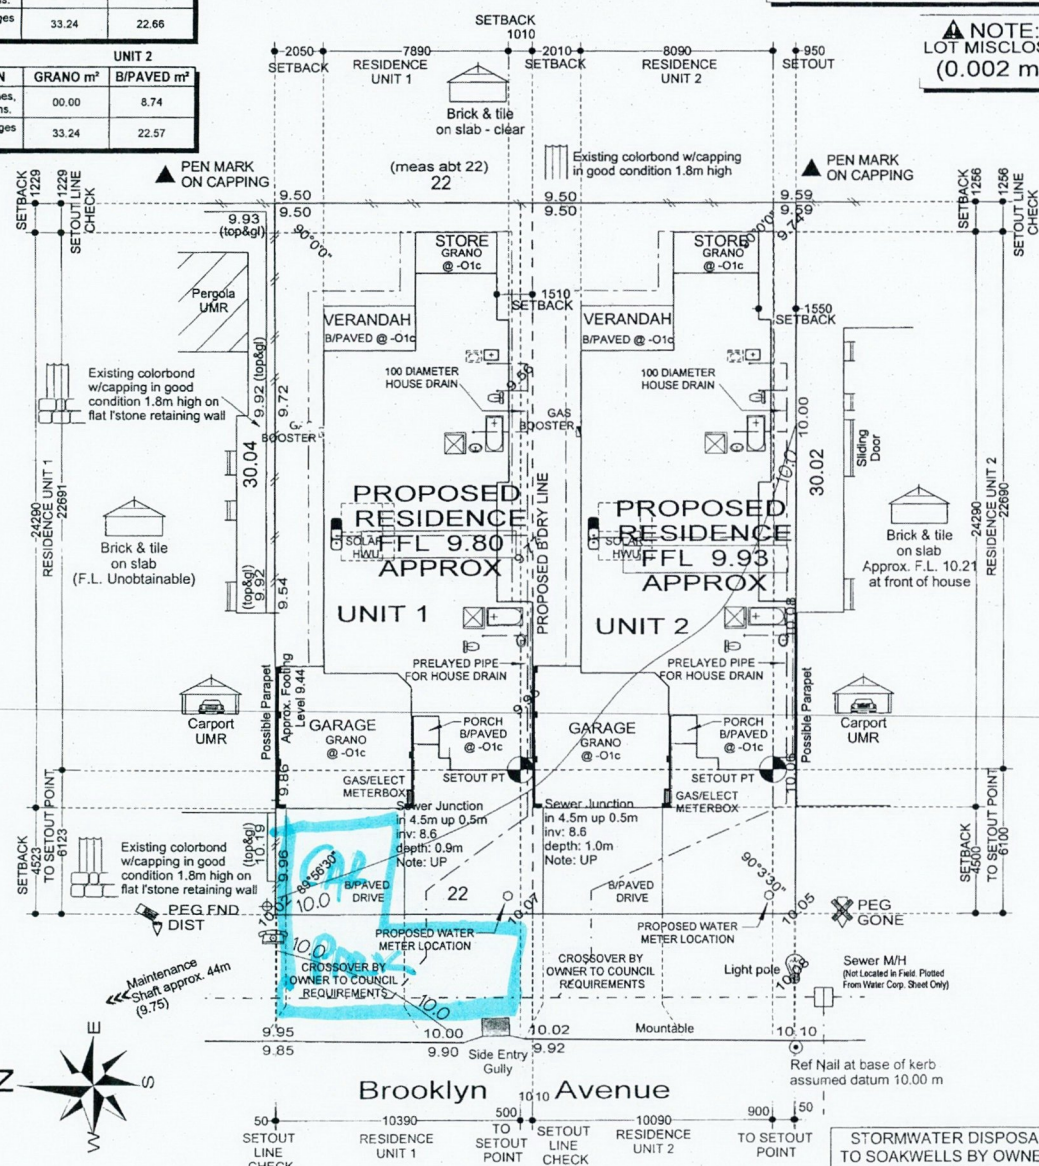COASTAL
NO.

A NOTE: COTTAGE & ENGINEERING SURVEYS ACCEPT NO RESPONSIBILITY FOR ANY PHYSICAL ON SITE CHANGES TO THE PARCEL OR PORTION OF THE PARCEL OF LAND SHOWN ON THIS SURVEY INCLUDING ANY ADJOINING NEIGHBOURS LEVELS AND FEATURES THAT HAVE OCCURRED AFTER THE DATE ON THIS SURVEY



Scale 1:200




0 2 4 6 8 10


Scale 1:200 Date: 27/10/2004

NOTE: All Sewer details plotted from information supplied by Water Corporation.

 NOTE/BEWARE: ADVISE TRADES
O/Head power lines

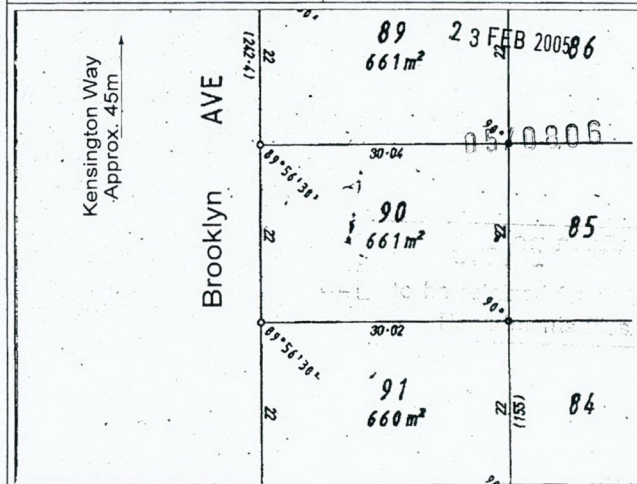

Elec.	 <u>U/ground</u>	Water	 <u>Yes</u>	Sewer	<u>Yes</u>
Gas	<u>Alinta Gas Map Indicates Gas In Area</u> <u>Check Your Lot call 13135</u>	Phone	 <u>Yes</u>	Footpath	<u>Nil</u>
Road	<u>Bitumen</u>	Kerb	<u>Mountable</u>	Drainage	<u>Good</u>

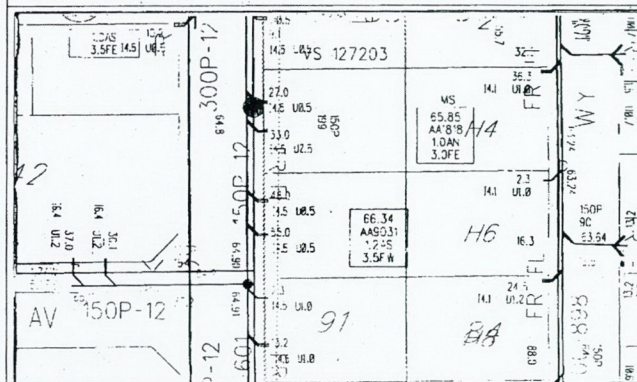

COTTAGE & ENGINEERIN G
SURVEYS
— Licensed Surveyors — © J/No. 118171 Drawn: G. Castellas

NOTE: * EARTHWORKS / SET-OUT DIMENSIONS MAY VARY ON SITE AT BUILDERS DISCRETION. ** SLOPE / DRAINAGE MAY VARY FROM SCHEMATIC PRESENTATION / CHECK MINIMUM CLEARANCES. RETAINING NOT INCLUDED IN CONTRACT. ** REMAINS OWNERS RESPONSIBILITY. THIS SURVEY DOES NOT GUARANTEE THE LOCATION OF BOUNDARY PEGS OR FENCES. CHECK TITLE FOR EASEMENTS / COVENANTS ETC.

! NOTE :